


- NOTES:**
1. BEARINGS ARE BASED ON STATE PLANE COORDINATE SYSTEM, MAINE WEST ZONE, NAD 83, DERIVED FROM POST PROCESSED GPS OBSERVATIONS.
  2. ELEVATIONS ARE BASED ON NAVD 88, DERIVED FROM POST PROCESSED GPS OBSERVATIONS.
  3. PROPERTY LINES ARE BASED ON TAX MAPS AND MARKERS FOUND AND ARE NOT THE RESULT OF SURVEYS OF THE INDIVIDUAL LOTS.
  4. THE UNDERGROUND UTILITIES SHOWN HAVE BEEN LOCATED FROM FIELD SURVEY INFORMATION AND EXISTING DRAWINGS. THE SURVEYOR MAKES NO GUARANTEES THAT THE UNDERGROUND UTILITIES SHOWN COMPRISE ALL SUCH UTILITIES IN THE AREA, EITHER IN SERVICE OR ABANDONED. THE SURVEYOR FURTHER DOES NOT WARRANT THAT THE UNDERGROUND UTILITIES SHOWN ARE IN THE EXACT LOCATION INDICATED ALTHOUGH HE DOES CERTIFY THAT THEY ARE LOCATED AS ACCURATELY AS POSSIBLE FROM INFORMATION AVAILABLE. THE SURVEYOR HAS NOT PHYSICALLY LOCATED THE UNDERGROUND UTILITIES. CALL 1-888-DIGSAFE AT LEAST THREE BUSINESS DAYS BEFORE PERFORMING ANY CONSTRUCTION. DUE TO OSHA CONFINED SPACE REQUIREMENTS, ALL INVERTS AND PIPE SIZES MUST BE VERIFIED PRIOR TO ANY CONSTRUCTION.
  5. SAW MILL HILL UTILITY AND INVERT INFORMATION, AND TOPOGRAPHY BETWEEN MOULTON STREET AND SALMON FALL RIVER TAKEN FROM PLAN REFERENCE 1.

**LEGEND**

●	IRON PIPE OR ROD FOUND	✕	FENCE
■	MONUMENT FOUND	— — —	STONEWALL
○	UTILITY POLE	— — —	CURB
○	MANHOLE	— — —	OVERHEAD WIRES
⊗	ELECTRIC METER	— — —	WATER LINE
⊕	SIGN	— — —	STORM DRAIN
⊖	CATCH BASIN	— — —	SANITARY SEWER
⊙	HYDRANT	— — —	1' CONTOUR
⊗	WATER VALVE OR SHUTOFF	— — —	IRON PIPE OR ROD FOUND
⊙	LIGHT POLE	TM	TAX MAP - LOT NO.
⊙	DECIDUOUS TREE	N/F	NOW OR FORMERLY DEED BOOK / PAGE
⊙	CONIFEROUS TREE	000/000	
⊙	SHRUB/BUSH	L/S	LANDSCAPED AREA
		CONC.	CONCRETE

**PLAN REFERENCE:**

1. "EXISTING CONDITIONS SURVEY MOULTON STREET, BERWICK, MAINE", DATED APRIL 26, 2019, LAST REV. MAY 8, 2019 BY OWEN HASKELL, INC., SHEETS SV-101 & SV-102
2. "EXISTING CONDITIONS PLAN, LAND OF PUBLIC SERVICE OF NH (D.B.A. EVERSOURCE ENERGY) (TAX MAP U1, LOT 74) SAW MILL HILL ROAD & MOULTON STREET, BERWICK, MAINE FEB. 2016" BY DOUCET SURVEY INC.

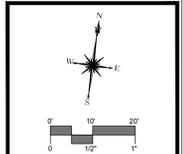

DESCRIPTION	DATE	BY


**EXISTING CONDITIONS PLAN**  
**STORMWATER & ROAD IMPROVEMENTS**  
**OUTFALL #007**  
**MOULTON STREET**  
**BERWICK, MAINE**

CONCEPT PLANS  
NOT FOR CONSTRUCTION

PFH DESIGNED	PFH DRAWN	JQA CHECKED
SCALE 1" = 20'		
DATE MAY 17, 2019		
PROJECT NO. 6744-02		
SHEET NO. 01 OF XX		
SHEET NAME <b>EX-1</b>		

SALMON FALLS RIVER

1. EXISTING CONDITIONS SURVEY MOULTON STREET, BERWICK, MAINE, DATED APRIL 26, 2019, LAST REV. MAY 8, 2019 BY OWEN HASKELL, INC., SHEETS SV-101 & SV-102  
 2. EXISTING CONDITIONS PLAN, LAND OF PUBLIC SERVICE OF NH (D.B.A. EVERSOURCE ENERGY) (TAX MAP U1, LOT 74) SAW MILL HILL ROAD & MOULTON STREET, BERWICK, MAINE FEB. 2016" BY DOUCET SURVEY INC.

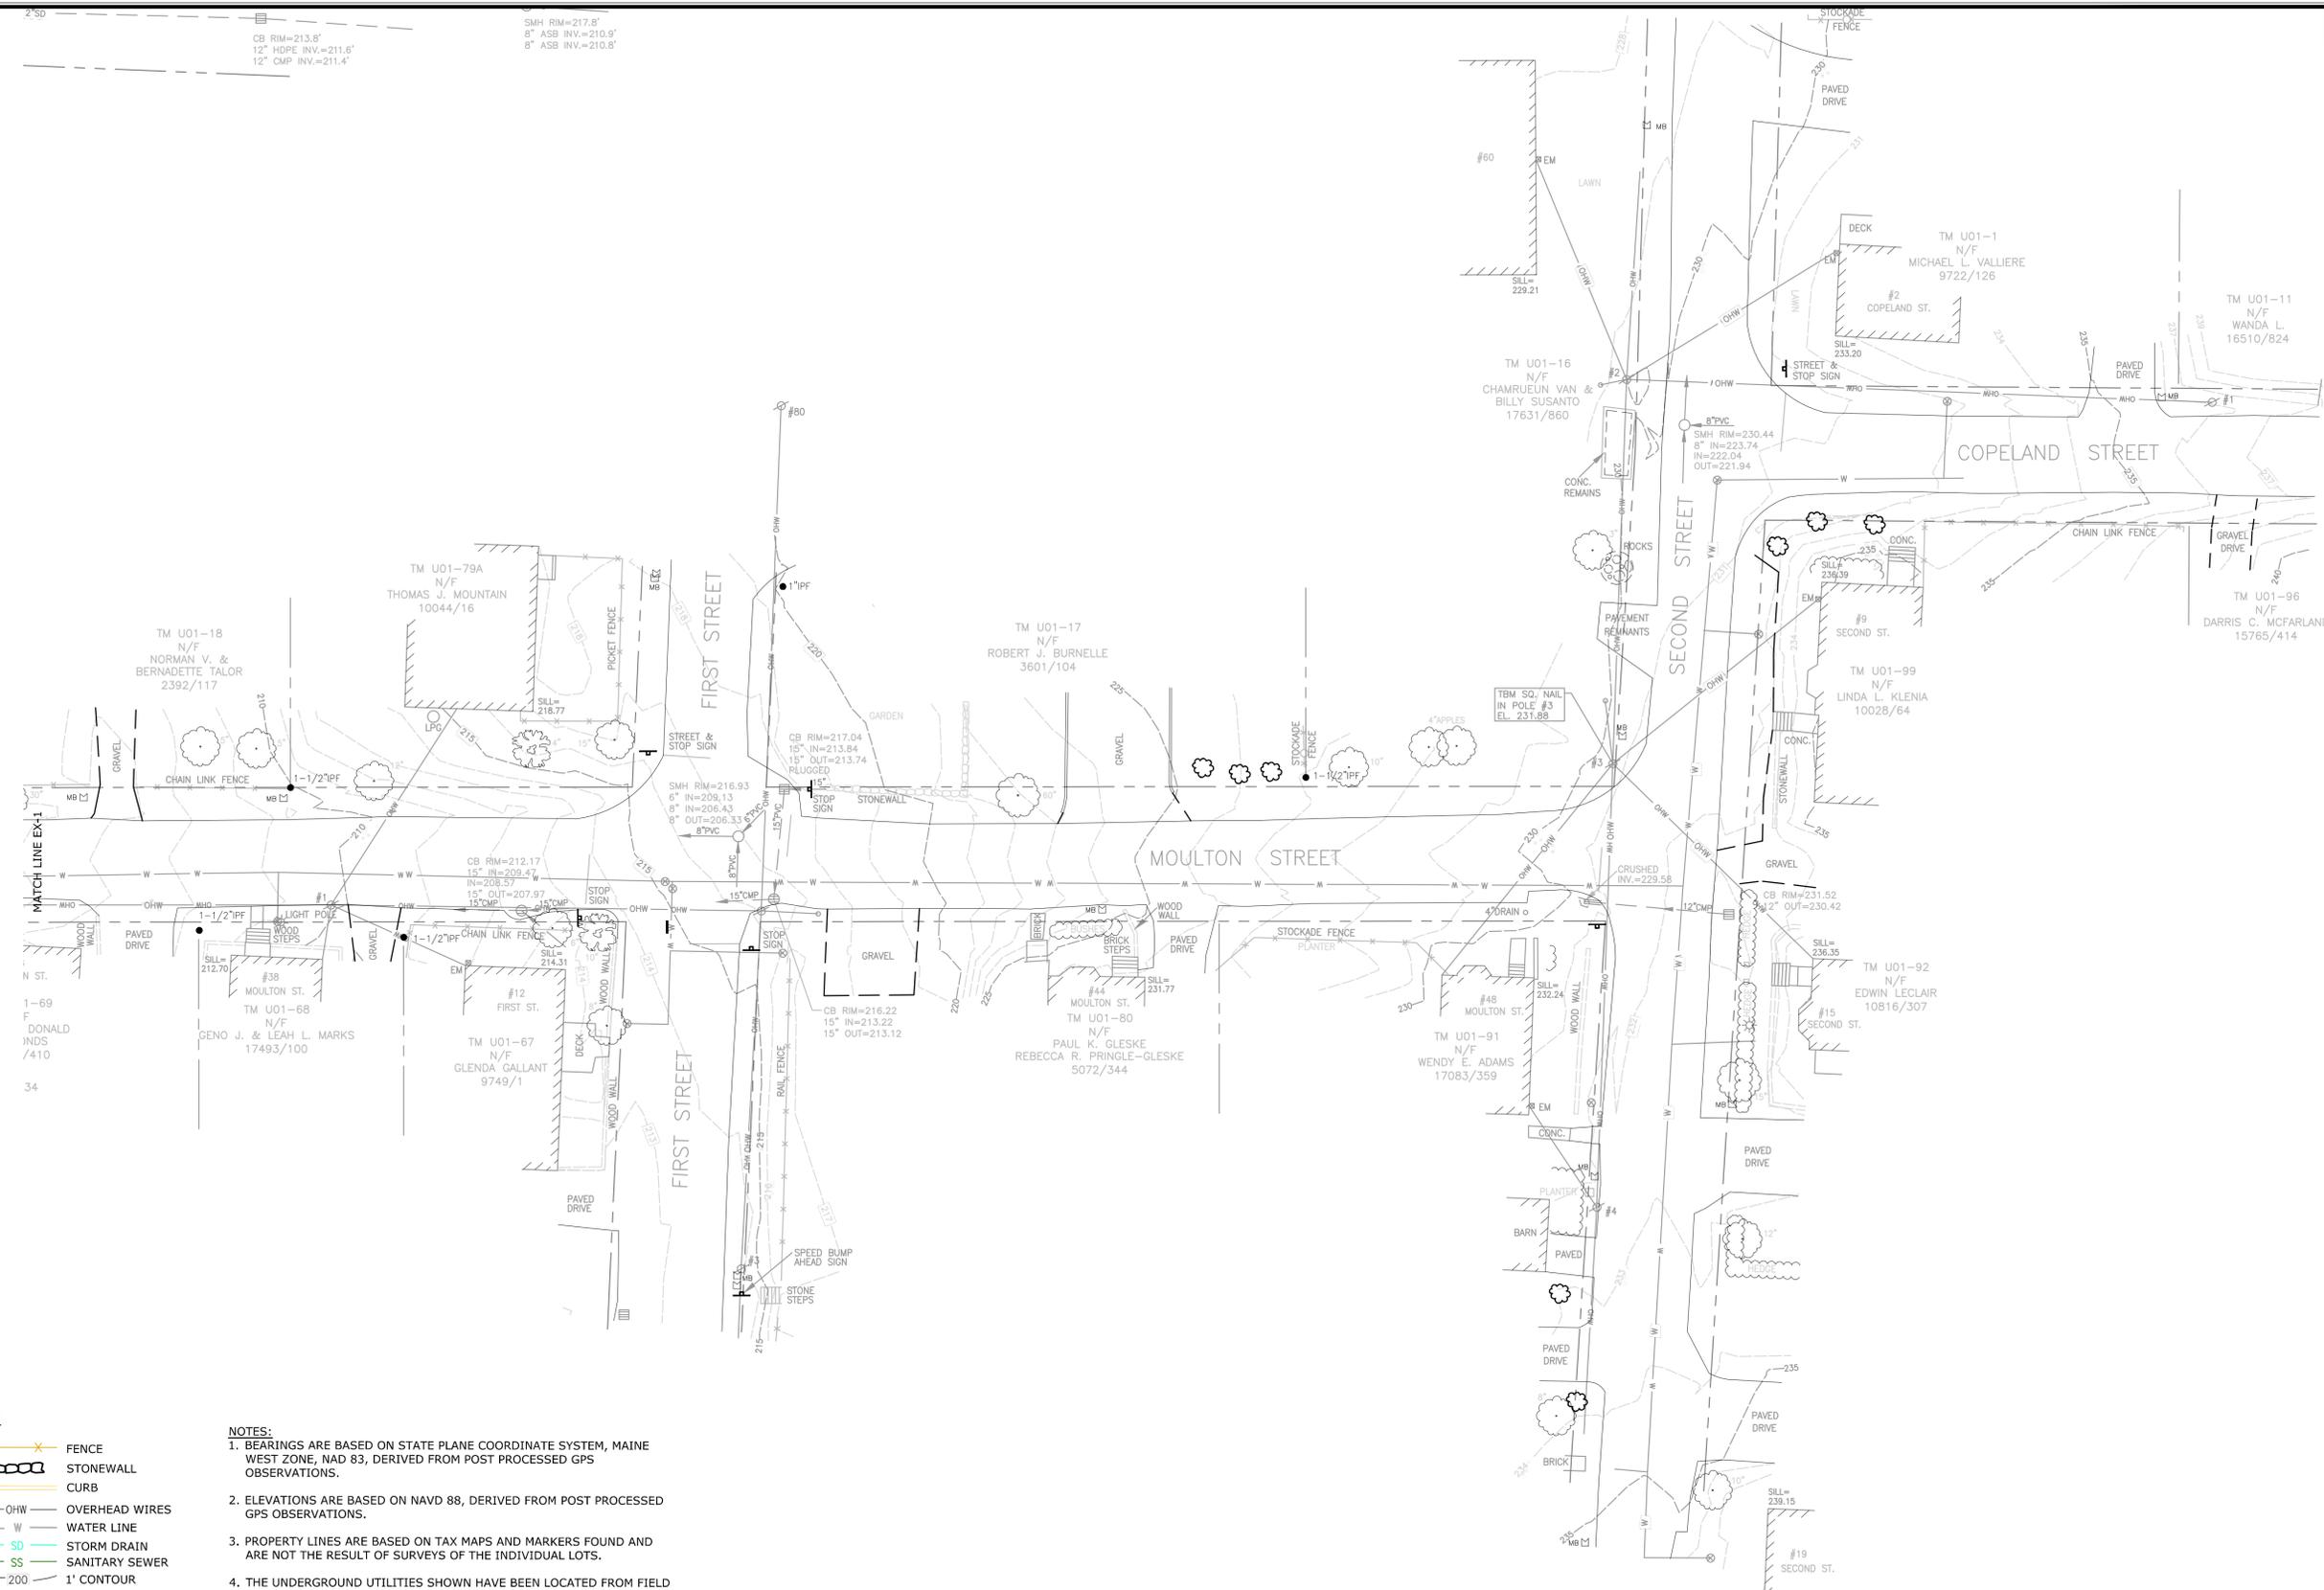


**LEGEND**

- |   |                        |         |                        |
|---|------------------------|---------|------------------------|
| ● | IRON PIPE OR ROD FOUND | ✕       | FENCE                  |
| ■ | MONUMENT FOUND         | ▬▬▬     | STONEWALL              |
| ○ | UTILITY POLE           | —       | CURB                   |
| ○ | MANHOLE                | —       | OHW                    |
| ⊗ | ELECTRIC METER         | —       | W                      |
| ⊕ | SIGN                   | —       | SD                     |
| ⊖ | CATCH BASIN            | —       | SS                     |
| ⊙ | HYDRANT                | —       | 200'                   |
| ⊗ | WATER VALVE OR SHUTOFF | IPF/IRF | IRON PIPE OR ROD FOUND |
| ⊙ | LIGHT POLE             | TM      | TAX MAP - LOT NO.      |
| ⊙ | DECIDUOUS TREE         | N/F     | NOW OR FORMERLY        |
| ⊙ | CONIFEROUS TREE        | 000/000 | DEED BOOK / PAGE       |
| ⊙ | SHRUB/BUSH             | L/S     | LANDSCAPED AREA        |
|   |                        | CONC.   | CONCRETE               |

**NOTES:**

- BEARINGS ARE BASED ON STATE PLANE COORDINATE SYSTEM, MAINE WEST ZONE, NAD 83, DERIVED FROM POST PROCESSED GPS OBSERVATIONS.
- ELEVATIONS ARE BASED ON NAVD 88, DERIVED FROM POST PROCESSED GPS OBSERVATIONS.
- PROPERTY LINES ARE BASED ON TAX MAPS AND MARKERS FOUND AND ARE NOT THE RESULT OF SURVEYS OF THE INDIVIDUAL LOTS.
- THE UNDERGROUND UTILITIES SHOWN HAVE BEEN LOCATED FROM FIELD SURVEY INFORMATION AND EXISTING DRAWINGS. THE SURVEYOR MAKES NO GUARANTEES THAT THE UNDERGROUND UTILITIES SHOWN COMPRISE ALL SUCH UTILITIES IN THE AREA, EITHER IN SERVICE OR ABANDONED. THE SURVEYOR FURTHER DOES NOT WARRANT THAT THE UNDERGROUND UTILITIES SHOWN ARE IN THE EXACT LOCATION INDICATED ALTHOUGH HE DOES CERTIFY THAT THEY ARE LOCATED AS ACCURATELY AS POSSIBLE FROM INFORMATION AVAILABLE. THE SURVEYOR HAS NOT PHYSICALLY LOCATED THE UNDERGROUND UTILITIES. CALL 1-888-DIGSAFE AT LEAST THREE BUSINESS DAYS BEFORE PERFORMING ANY CONSTRUCTION. DUE TO OSHA CONFINED SPACE REQUIREMENTS, ALL INVERTS AND PIPE SIZES MUST BE VERIFIED PRIOR TO ANY CONSTRUCTION.
- SAW MILL HILL UTILITY AND INVERT INFORMATION, AND TOPOGRAPHY BETWEEN MOULTON STREET AND SALMON FALL RIVER TAKEN FROM PLAN REFERENCE 1.

**PLAN REFERENCE:**  
 1. "EXISTING CONDITIONS SURVEY MOULTON STREET, BERWICK, MAINE", DATED APRIL 26, 2019, LAST REV. MAY 8, 2019 BY OWEN HASKELL, INC., SHEETS SV-101 & SV-102  
 2. "EXISTING CONDITIONS PLAN, LAND OF PUBLIC SERVICE OF NH (D.B.A. EVERSOURCE ENERGY) (TAX MAP U1, LOT 74) SAW MILL HILL ROAD & MOULTON STREET, BERWICK, MAINE FEB. 2016" BY DOUCET SURVEY INC.

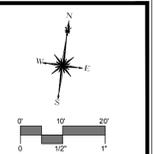

**MILONE & MACBROOM**  
 123 MIDDLE STREET, SUITE 201  
 PORTLAND, ME 04101  
 WWW.MILONE.COM

DESCRIPTION	DATE	BY

**CONCEPT PLANS  
 NOT FOR CONSTRUCTION**


**EXISTING CONDITIONS PLAN**  
**STORMWATER & ROAD IMPROVEMENTS**  
**OUTFALL 007**  
 MOULTON STREET  
 BERWICK, MAINE

PFH	PFH	JQA
DESIGNED	DRAWN	CHECKED
SCALE 1" = 20'		
DATE MAY 17, 2019		
PROJECT NO. 6744-02		
SHEET NO. 02 OF XX		

**EX-2**






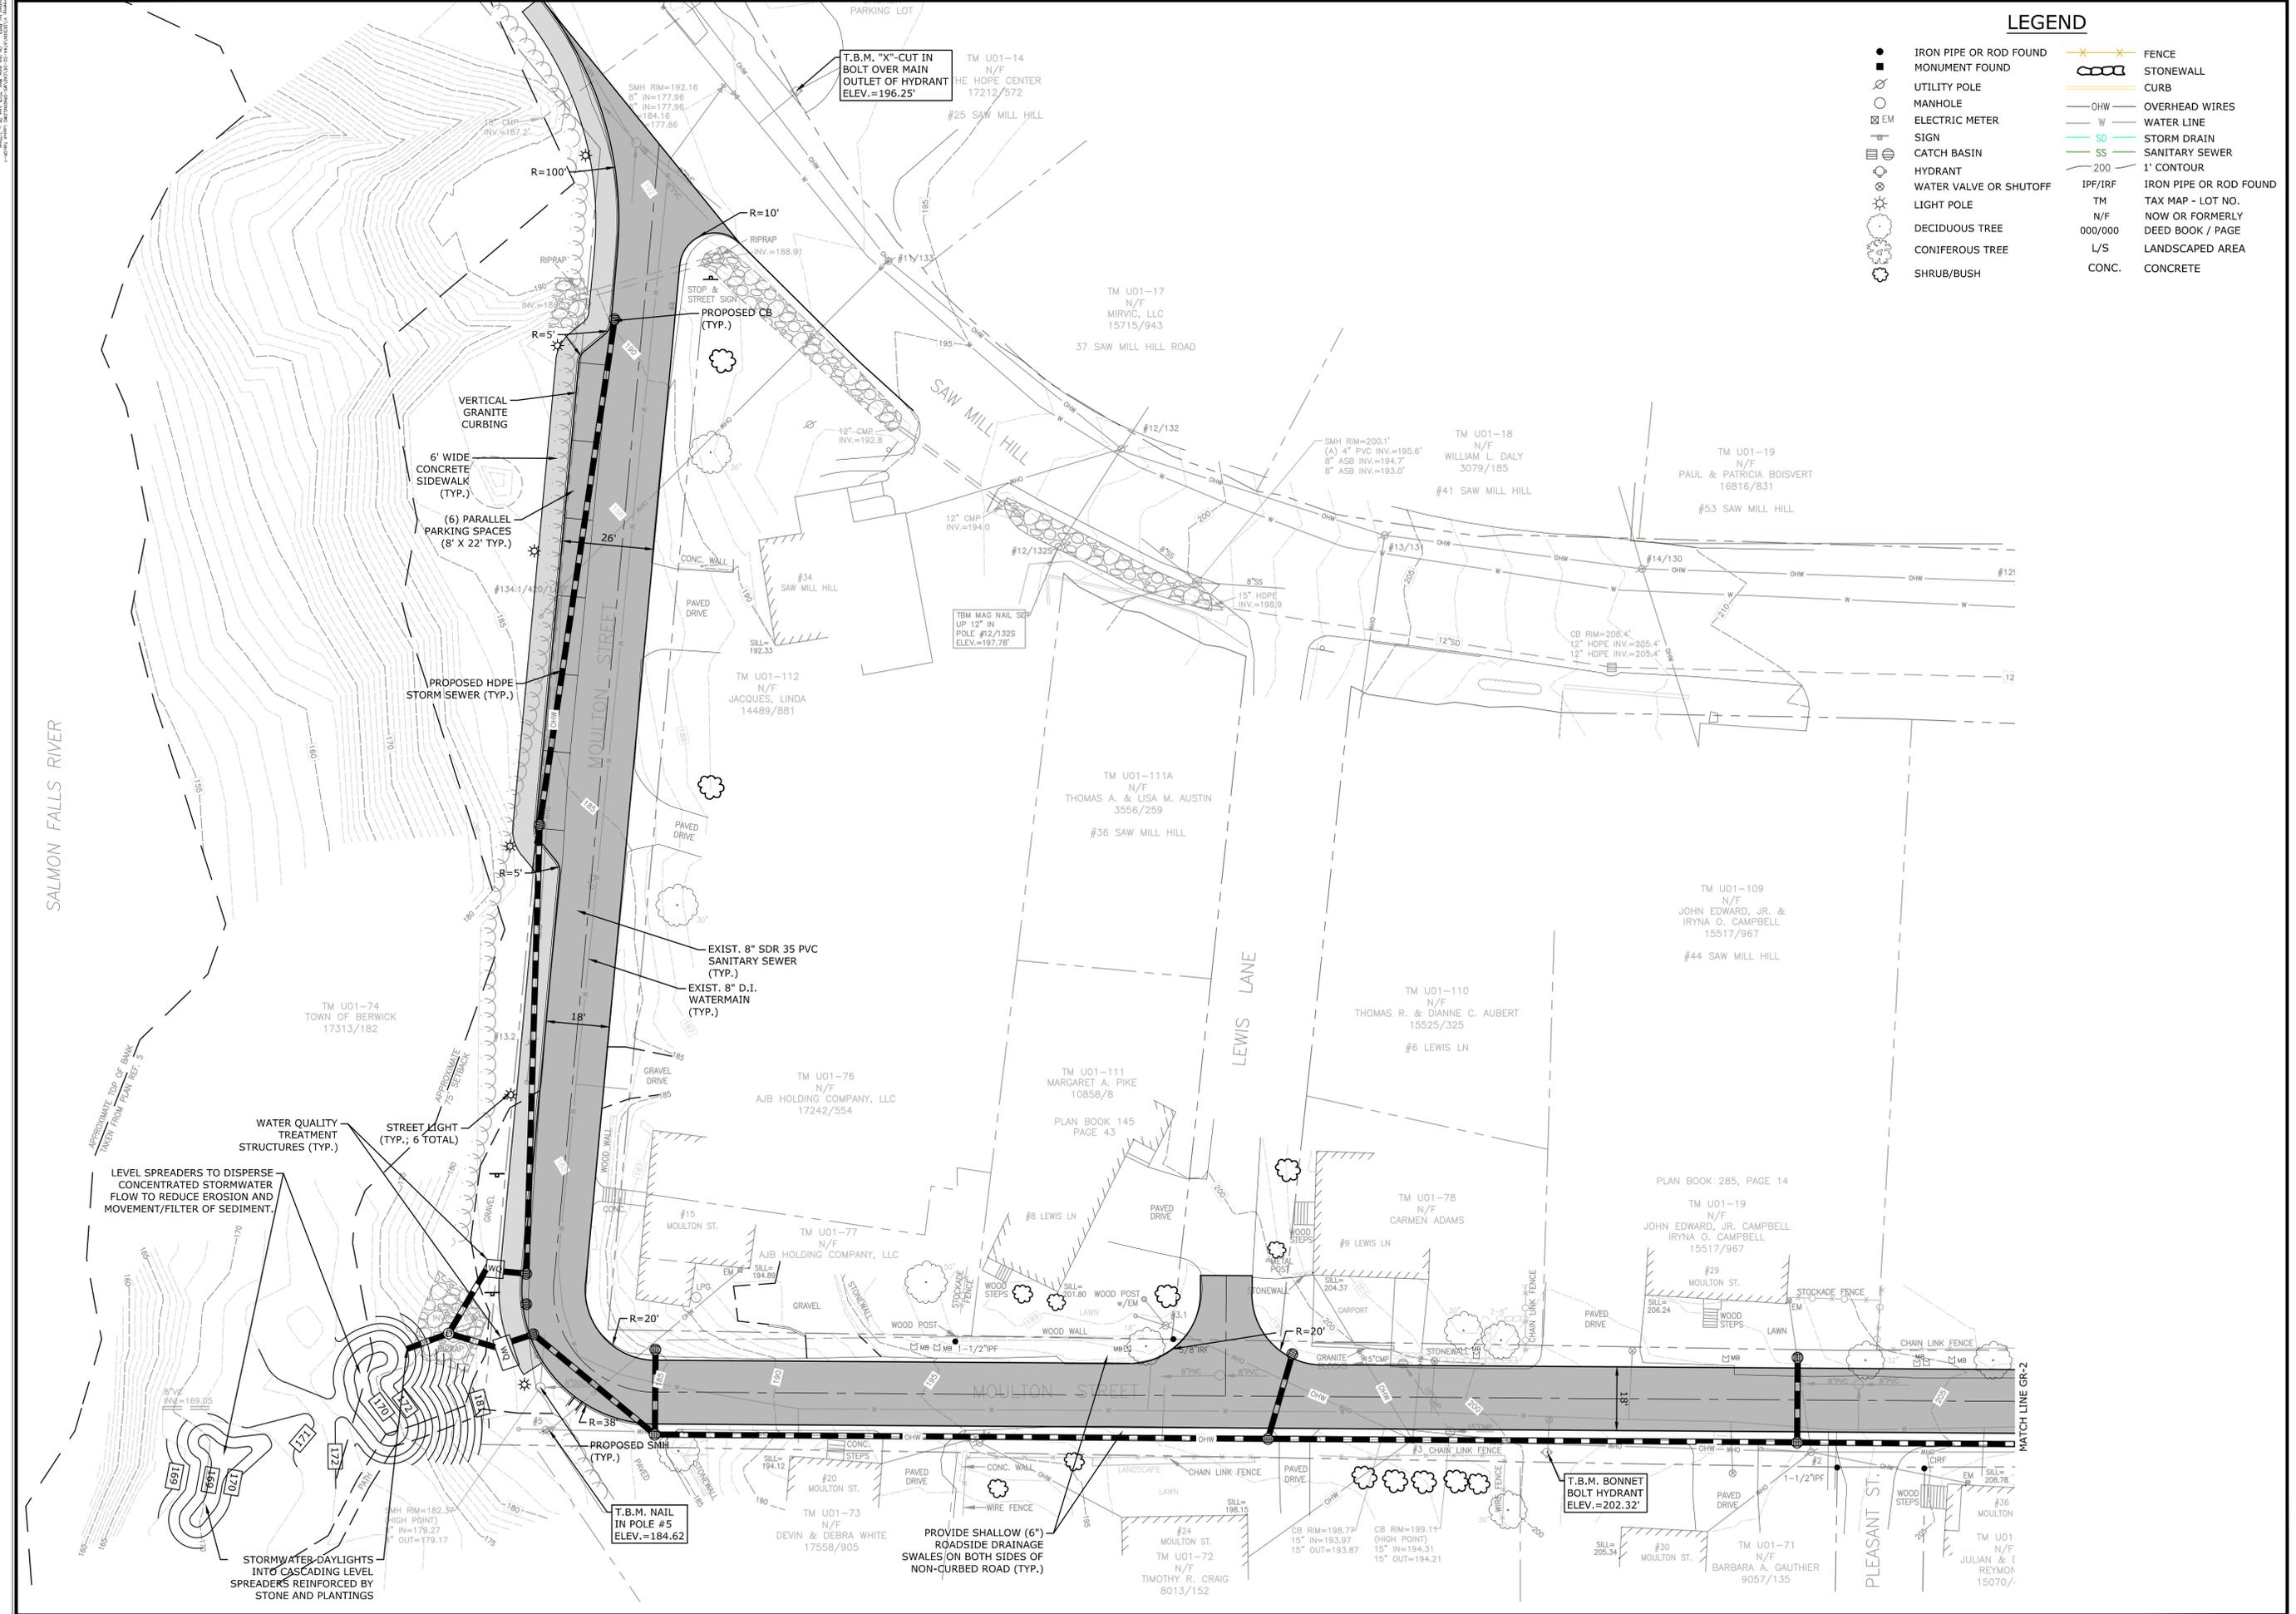

**LEGEND**

●	IRON PIPE OR ROD FOUND	—X—X—	FENCE
■	MONUMENT FOUND	—	STONEWALL
○	UTILITY POLE	—	CURB
○	MANHOLE	—	OVERHEAD WIRES
⊗	ELECTRIC METER	—	WATER LINE
⊕	SIGN	—	STORM DRAIN
⊖	CATCH BASIN	—	SANITARY SEWER
⊙	HYDRANT	—	1' CONTOUR
⊗	WATER VALVE OR SHUTOFF	—	IPF/IRF
⊙	LIGHT POLE	—	TM
⊙	DECIDUOUS TREE	—	N/F
⊙	CONIFEROUS TREE	—	000/000
⊙	SHRUB/BUSH	—	L/S
		—	CONC.

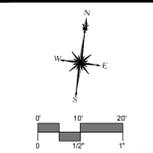

DESCRIPTION	DATE	BY

**CONCEPT PLANS  
NOT FOR CONSTRUCTION**

**GRADING PLAN**  
**STORMWATER & ROAD IMPROVEMENTS**  
**OUTFALL 007**  
**MOULTON STREET**  
**BERWICK, MAINE**

DESIGNED	PFH	JQA
DRAWN	PFH	CHECKED
SCALE	1" = 20'	
DATE	MAY 17, 2019	
PROJECT NO.	6744-02	
SHEET NO.	05 OF XX	

**GR-1**

